


1200  
3RD ST

BOX #2 - APPROXIMATELY  
5 FT HIGH X 3 FEET WIDE.

BOX #1 - APPROXIMATELY  
6 FT HIGH X 3 FEET WIDE.



P:\09010.100\_Public Safety Building\Drawings\EXHIBITS\SITE STRUCTURE.dwg doug.z Dec 01, 2011 - 11:44am

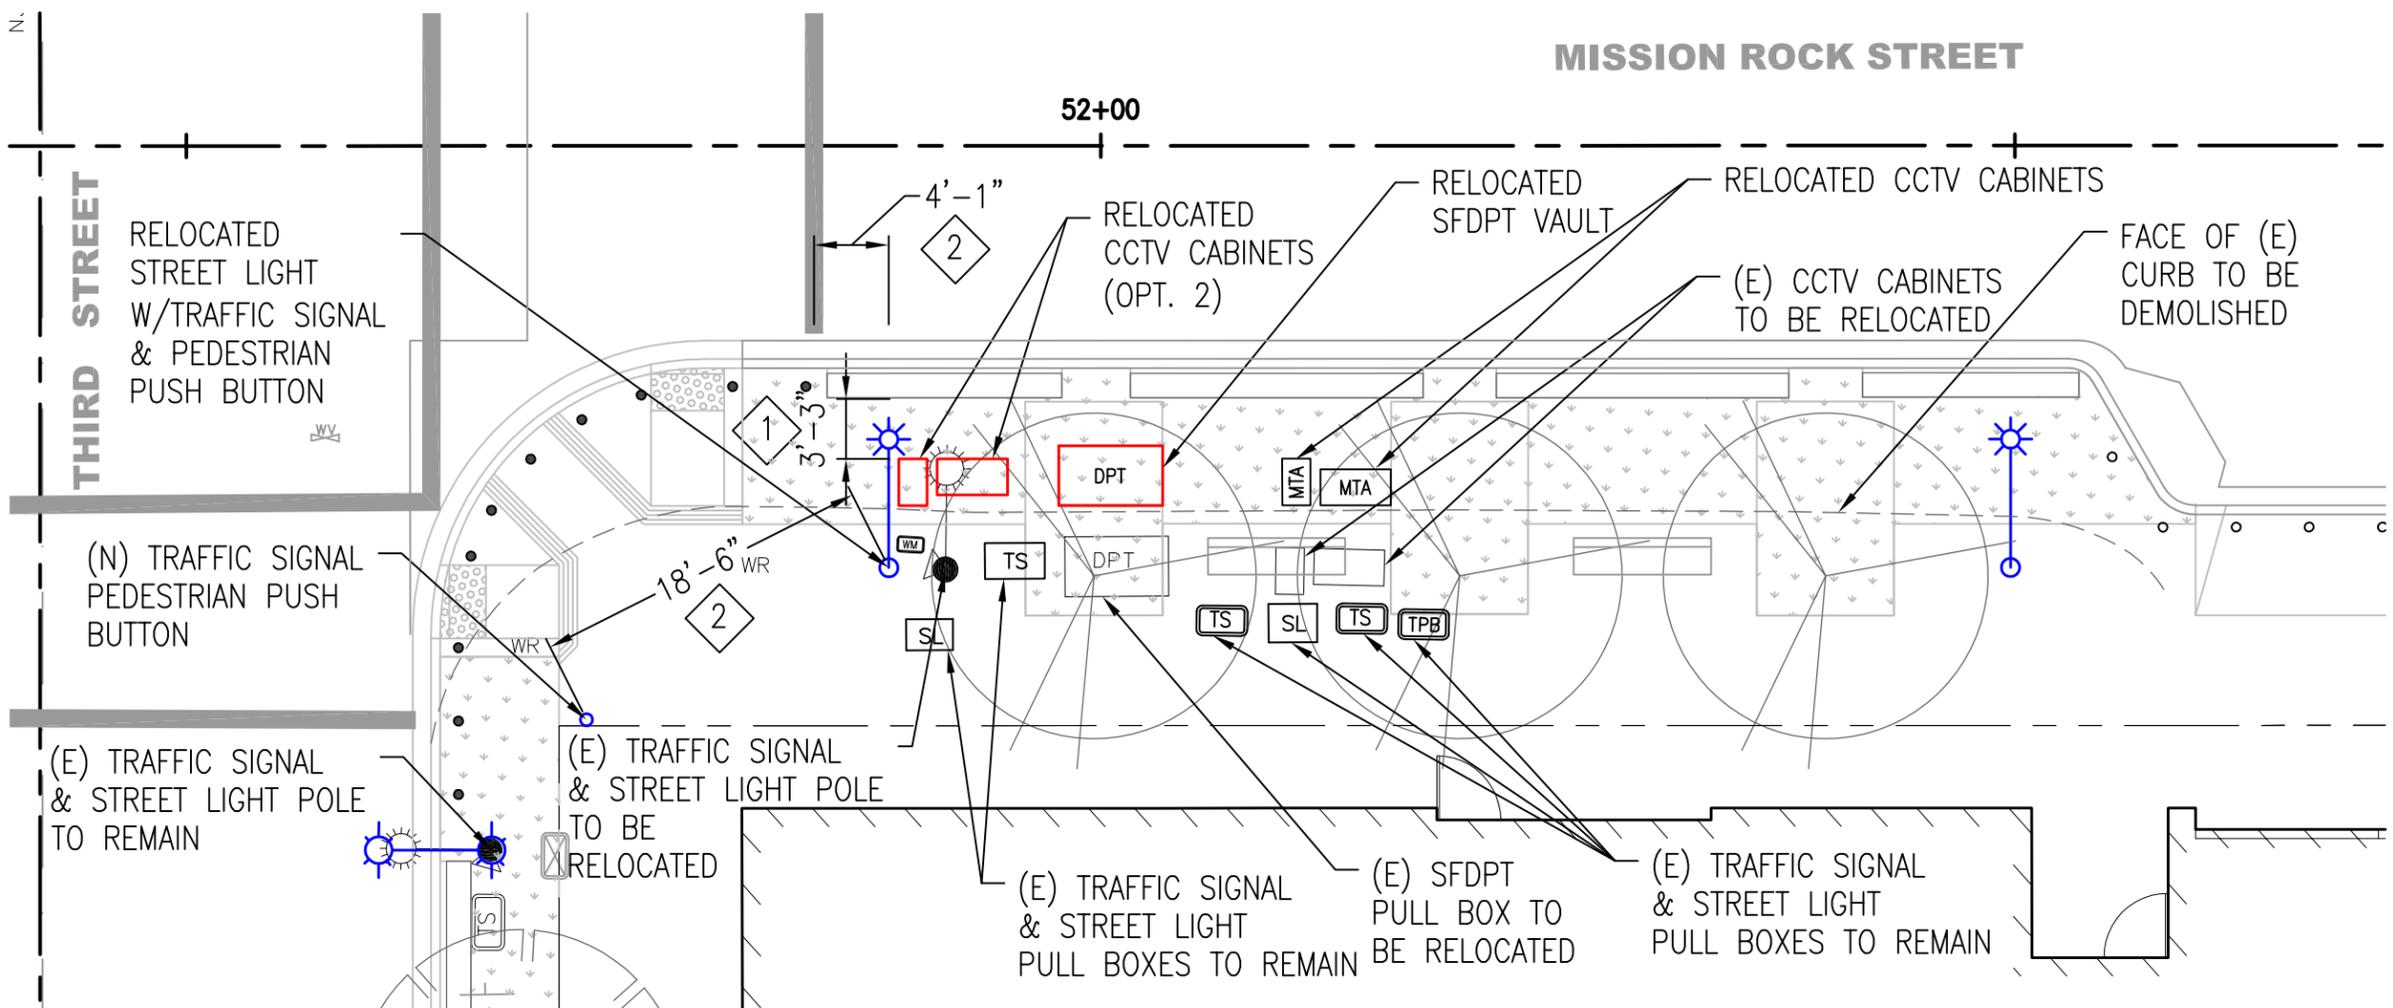


**LEGEND & ABBREVIATION**

- FIXED BOLLARD
- OPERABLE BOLLARD
- ▬ SITE BENCH
- ▬ ANTI-RAM BARRIER WALL

◇ NOTES:

1. CLEAR DIMENSION IS FROM EDGE OF COMMUNICATION CABINETS TO FACE OF ANTI-RAM BARRIER WALL.
2. DIMENSIONS FOR PEDESTRIAN PUSH BUTTONS ARE IN COMPLIANCE WITH MUTCD STANDARDS.
3. STREET TREES SHALL BE COORDINATED WITH THE MBDG & SHALL BE A SPECIES AND SIZE IN ACCORDANCE WITH THE MISSION BAY STREETSCAPE MASTER PLAN.
4. ALL ANTI-RAM DEVICES & FOOTINGS SHALL BE COORDINATED WITH PROPOSED UTILITIES.

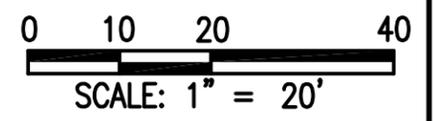


855 FOLSOM STREET, SUITE 142  
 SAN FRANCISCO, CA 94107  
 TEL: 415-837-1336 FAX: 415-837-1354

DESIGNED DZ	DATE	DATE
DRAWN FB	DATE	09/21/2011
CHECKED MC	DATE	SCALE 1" = 20'

SAN FRANCISCO DPW BUREAU OF PROJECT MANAGEMENT  
 PUBLIC SAFETY BUILDING  
 CITY AND COUNTY OF SAN FRANCISCO  
 SITE STRUCTURE: MISSION ROCK STREET  
 (OPTION 2)

DRAWING NO.  
 1 OF 1

P:\09010.100\_Public Safety Building\Draw\EXHIBITS\SITE UTIL\Site Utility Plan.dwg doug.z Dec 01, 2011 - 12:05pm

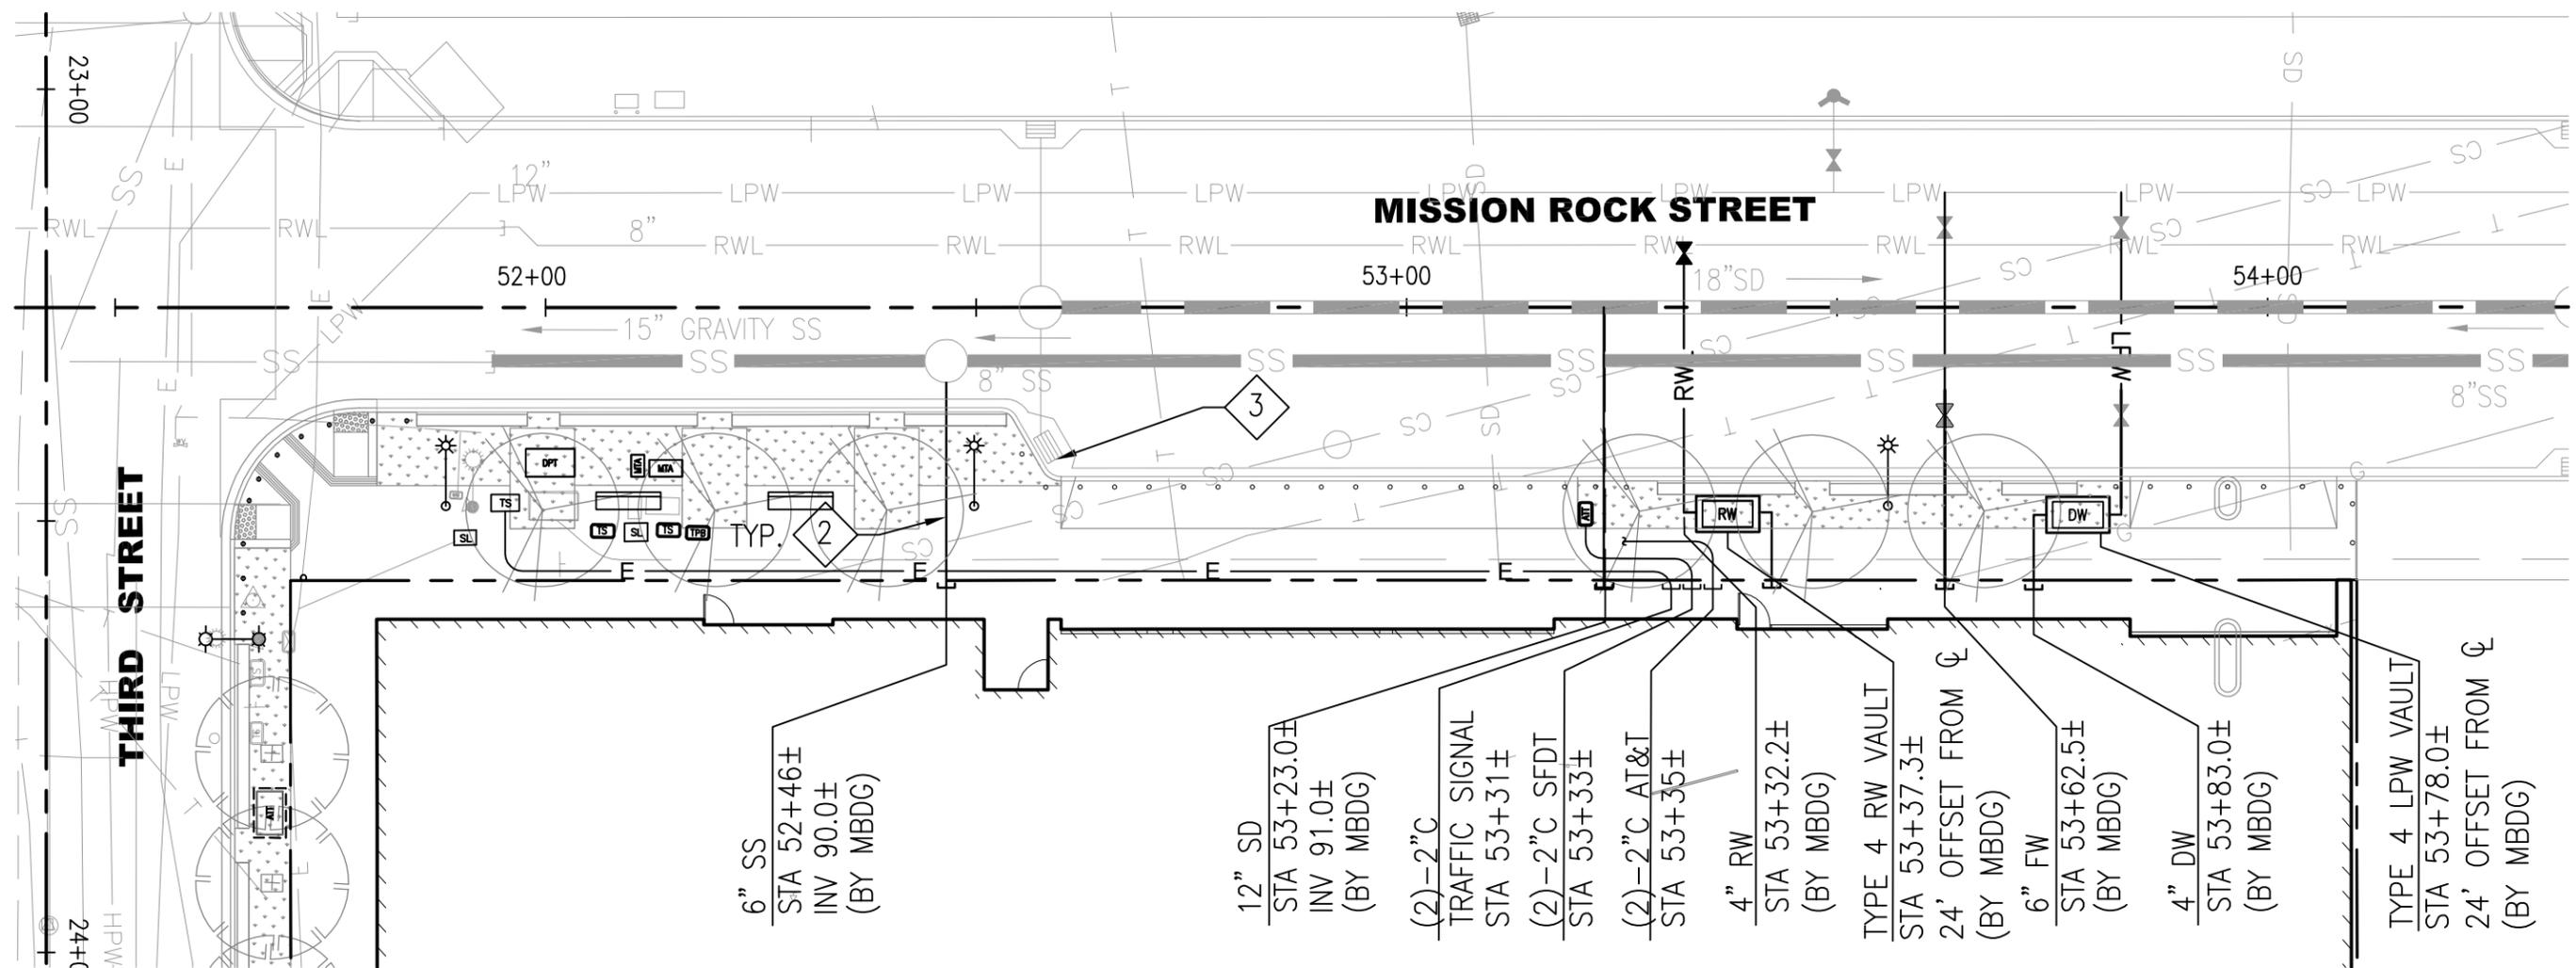


**LEGEND & ABBREVIATION**

	(N) UTILITY MAIN TO BE CONSTRUCTED BY MBDG
	PROPOSED FIRE HYDRANT
	RECLAIMED WATER LINE
	LOW PRESSURE WATER LINE
	FIRE WATER LINE
	STORM DRAIN
	SANITARY SEWER LINE

- 6" SS  
STA 52+46±  
INV 90.0±  
(BY MBDG)
- 12" SD  
STA 53+23.0±  
INV 91.0±  
(BY MBDG)
- (2)-2"C  
TRAFFIC SIGNAL  
STA 53+31±
- (2)-2"C SFDT  
STA 53+33±
- (2)-2"C AT&T  
STA 53+35±
- 4" RW  
STA 53+32.2±  
(BY MBDG)
- TYPE 4 RW VAULT  
STA 53+37.3±
- 24' OFFSET FROM C  
(BY MBDG)
- 6" FW  
STA 53+62.5±  
(BY MBDG)
- 4" DW  
STA 53+83.0±  
(BY MBDG)
- TYPE 4 LPW VAULT  
STA 53+78.0±  
24' OFFSET FROM C  
(BY MBDG)

 - NOTES:**
1. STATION CONTROL LINES AND OFFSETS ARE BASED ON THE 75% "MISSION BAY BLOCK 9/9A AND 10/10A PUBLIC IMPROVEMENT" PLANS DATED 9-22-04, PREPARED BY WINZLER & KELLY.
  2. ALL UTILITY LATERALS INCLUDING FIRE HYDRANT LATERAL SHALL BE CONSTRUCTED BY THE MBDG FROM MAIN TO 1' INSIDE PROPERTY LINE, AND COORDINATED WITH THE PUBLIC SAFETY BUILDING CONSTRUCTION.
  3. ALL STREET DRAINS ARE TO BE DESIGNED BY THE MBDG AND COORDINATED WITH THE PSB PROJECT.
  4. ROUTING OF PROPOSED ELECTRICAL LINES TO BE COORDINATED BETWEEN MBDG & PSB TEAM.



855 FOLSOM STREET, SUITE 142  
SAN FRANCISCO, CA 94107  
TEL: 415-837-1336 FAX: 415-837-1354

DESIGNED DZ	DATE	DATE
DRAWN FB	DATE	08/25/2011
CHECKED MC	DATE	SCALE 1" = 20'

SAN FRANCISCO DPW BUREAU OF PROJECT MANAGEMENT  
PUBLIC SAFETY BUILDING  
CITY AND COUNTY OF SAN FRANCISCO

SITE UTILITY: MISSION ROCK STREET

DRAWING NO.  
1 OF 1

