




REVISIONS BY APPR'D MANAGER, ENGIN		DESIGNED SECTION MAINAGER	ESIGN & CONSTRUCTION DIVISION	95% PROGRESS SET PUE	Сол			
NEERING MANAGEMENT BUREAU JOENERAL MANAGER, HETCH HETCHY WATER AND POWER $4-01$ drawing/tile no. Revision no. 0	277	DESIGNED	AND MATERIAL BINS BUILDING #76: ANDSCAPE LAYOUT PLAN	COUNTY OF SAI	CONTRACT NO. HH-982			

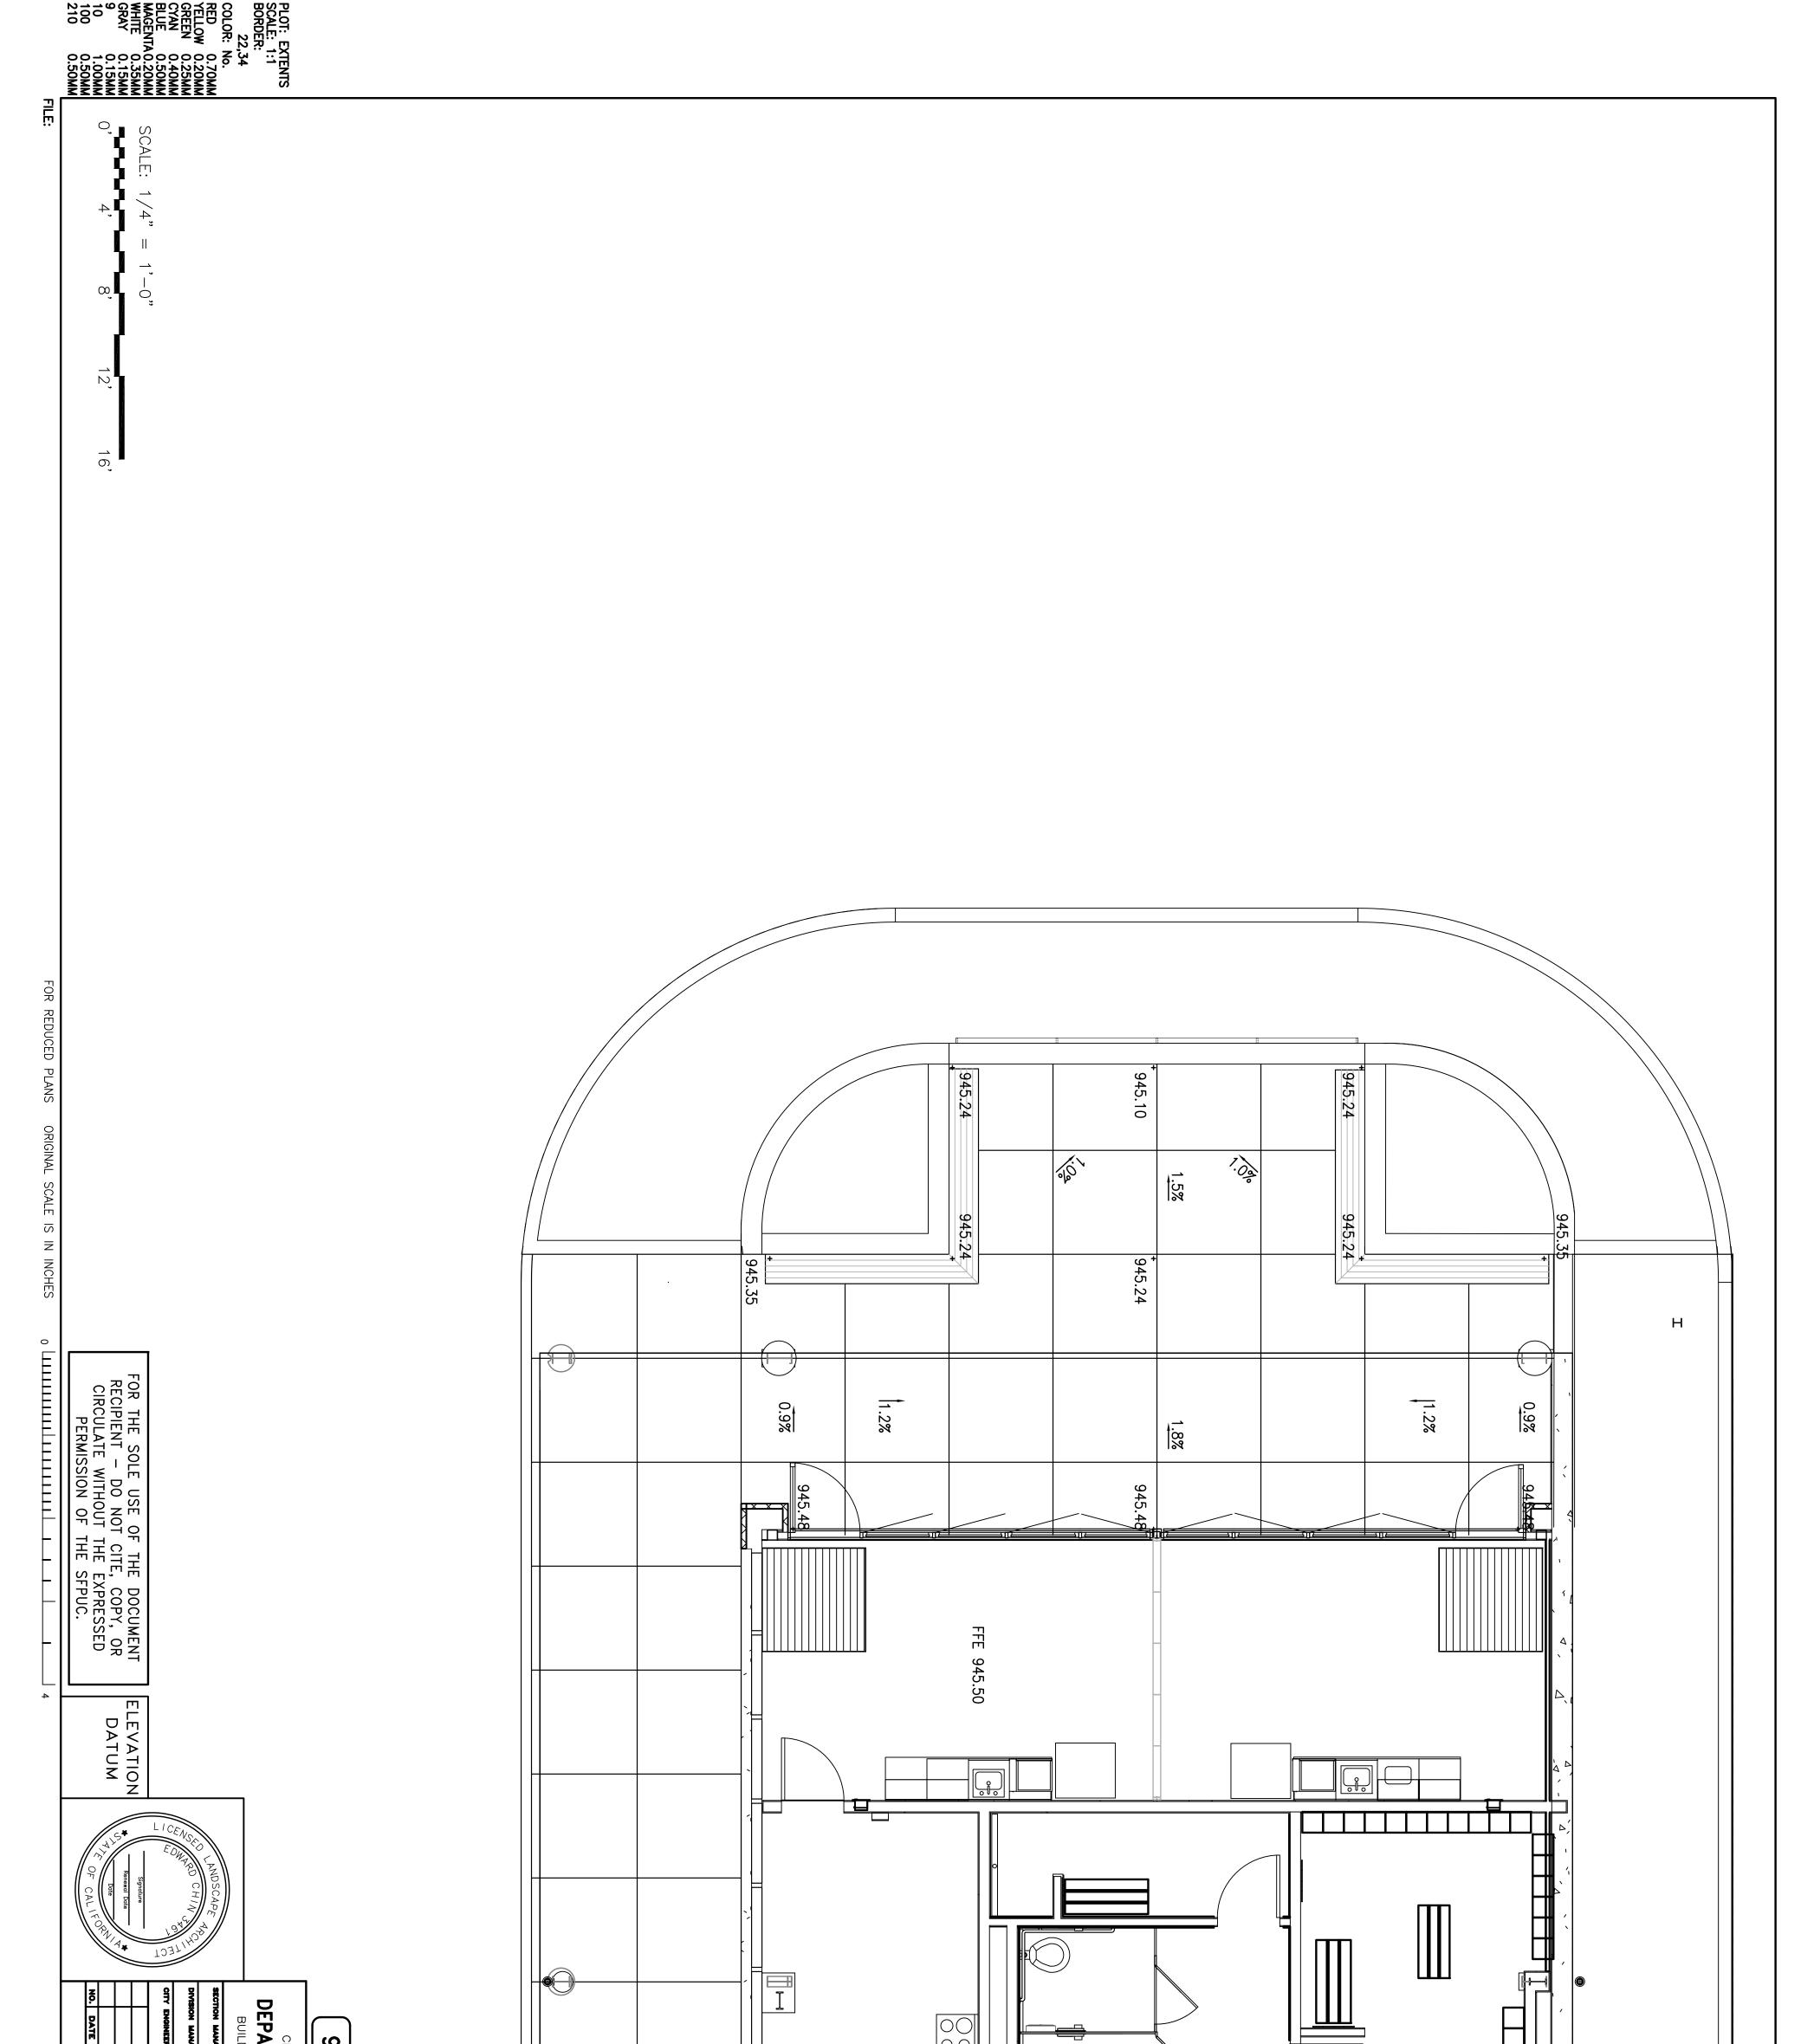

REVISIONS	95% PROGRESS SET		
manager, engineering management bureau general manager, hetch hetcht water and power plan no. $76 - \lfloor 4 - 02$ drawnho/file no. Revision no. 0	CONTRACT NO. HH-982 CITY AND COUNTY OF SAN FRANCISCO DITY AND COUNTY OF SAN FRANCISCO DITY AND COUNTY OF SAN FRANCISCO INFRASTRUCTURE DIVISION MOCCASIN SHOPS/OFFICE BUILDING MOTOR BUILDING #76: GRADING AND DRAINAGE PLAN ONNOTE INFROME INFROME INFRASTRUCTURE DIVISION INFRASTRUCTURE DIVISION INFRASTRUCTURE DIVISION INFRASTRUCTURE DIVISION INFRAST INFRASTRUCTURE DIVISION INFRAST INFRAST INFRAST INFRAST INFRAST INFRAST <td co<="" th=""><th></th></td>	<th></th>	

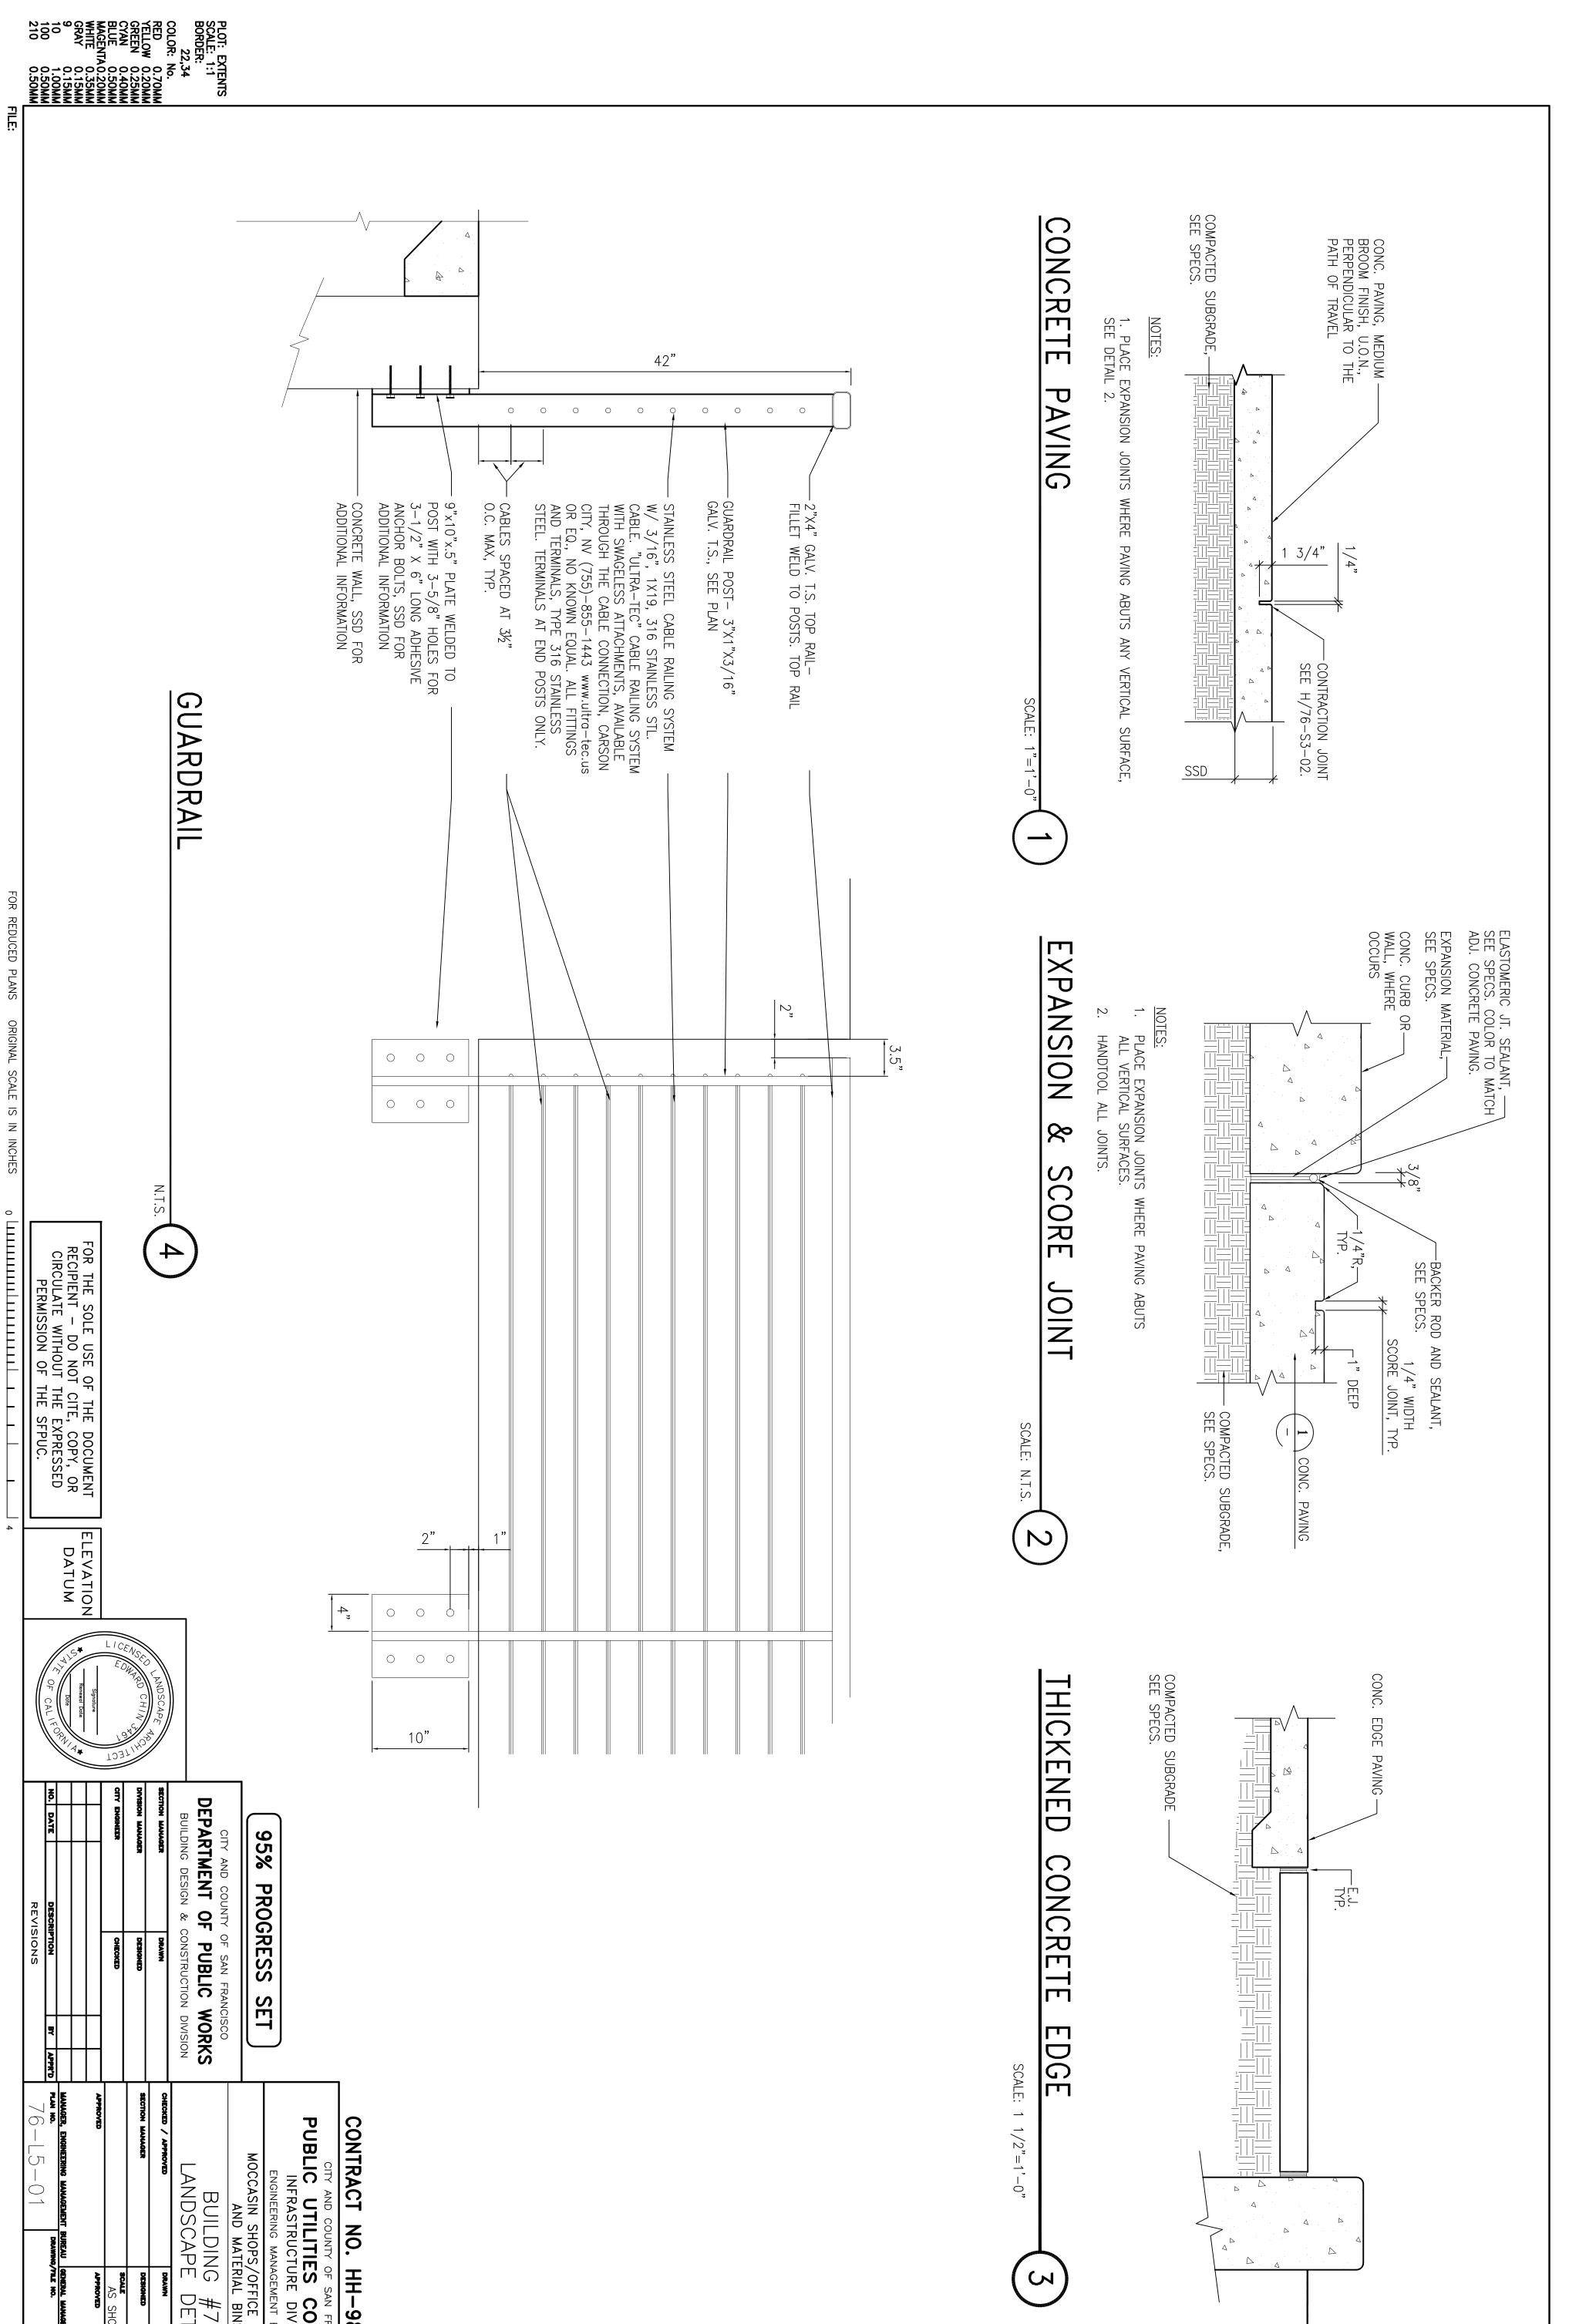


95% PROC CITY AND COUNTY PARTMENT OF BUILDING DESIGN &	95% PROGRESS SET		CONTRACT NO. HH-982 CITY AND COUNTY OF SAN FRANCISCO PUBLIC UTILITIES COMMISS INFRASTRUCTURE DIVISION INFRASTRUCTURE DIVISION ENGINEERING MANAGEMENT BUREAU MOCCASIN SHOPS/OFFICE BUILDING AND MATERIAL BINS BUILDING #76: LANDSCAPE DETAILS MORCED / APPONED SECTION MANAGEM		Image: Signature Image: Signature Imag
CITY AND COUNTY OF SAN FRANCISCO	OF SAN FRANCISCO PUBLIC WO CONSTRUCTION DIM	RKS SION	BUILDIN LANDSCAPI		
4 MANAGER 4 MANAGER	DRAWN DESIGNED		CHECKED / APPROVED	DESIGNED	
10INEER	CHECKED		APPROVED	SCALE DATE AS SHOWN AFFROVED	1 0/08/15
			MANAGER, ENGINEERING MANAGEMENT BUREAU GENERAL MANAGER, HETCH HETCHY WATER AND POWER	general hanager, hetch hetch	r water and power
DATE DESCRIPTION	REVISIONS	APPR'D	76-L5-01	TILE NO.	REVISION NO.

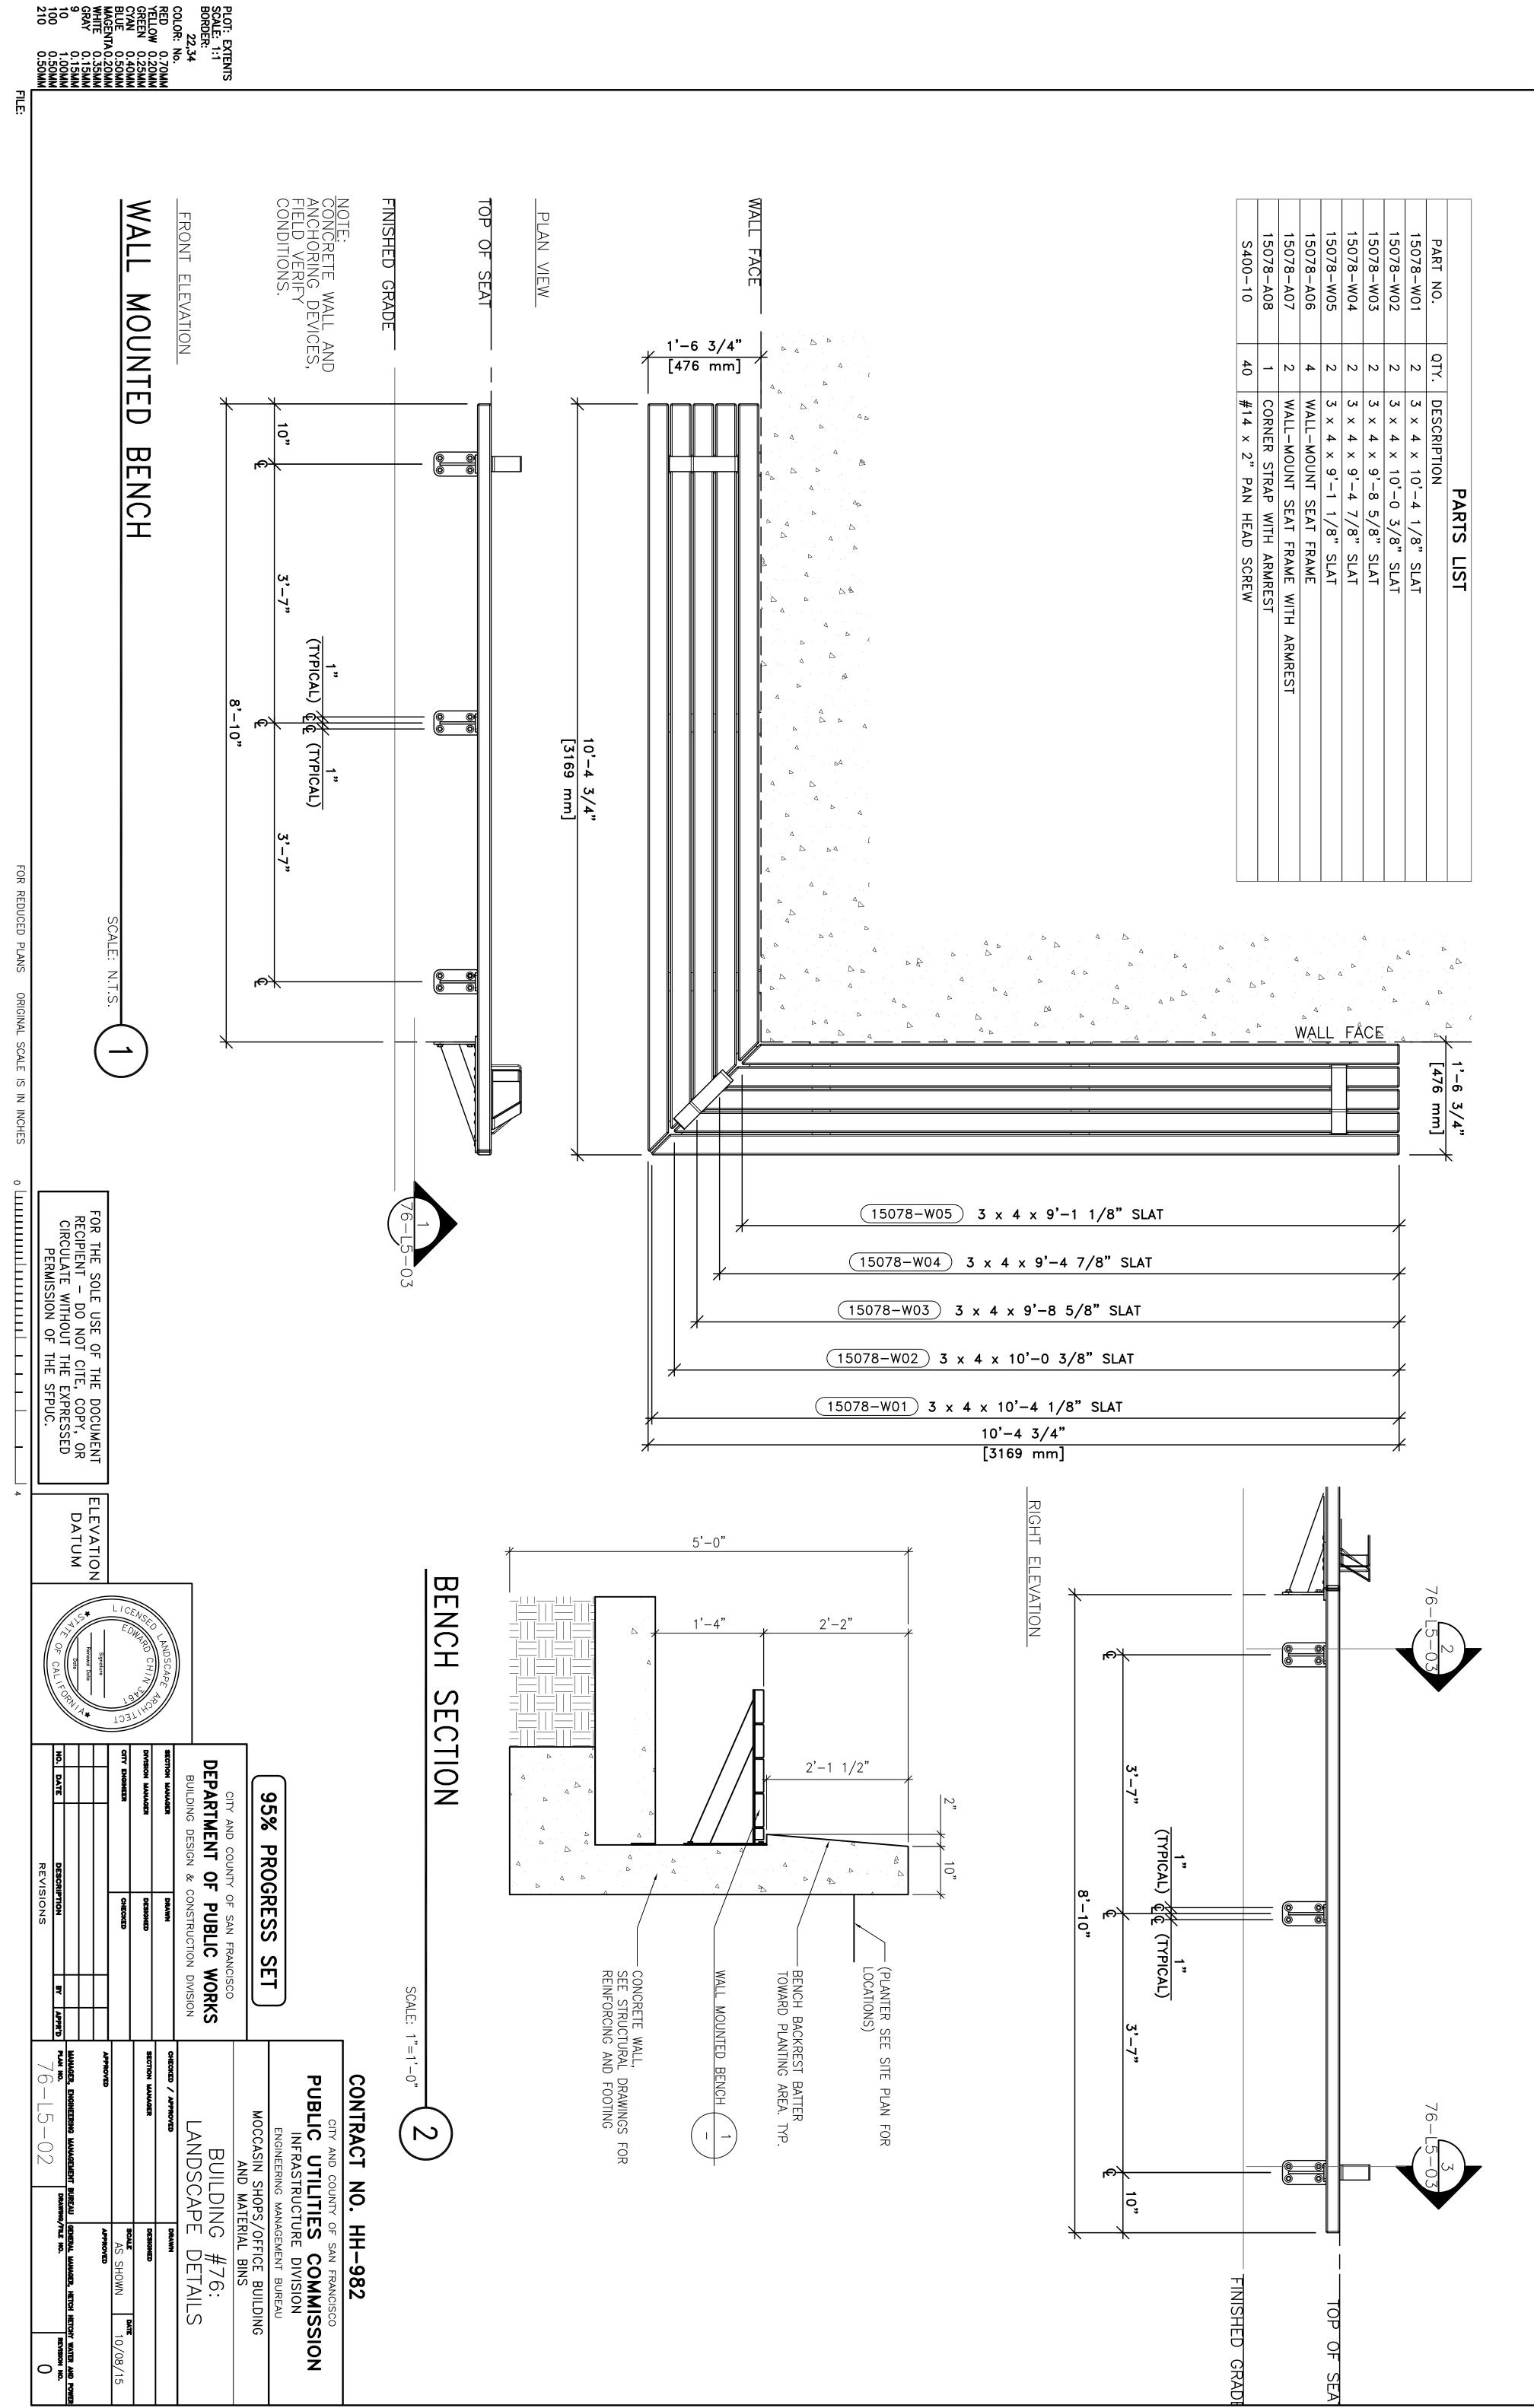


100 210

COLOR: RED YELLOY




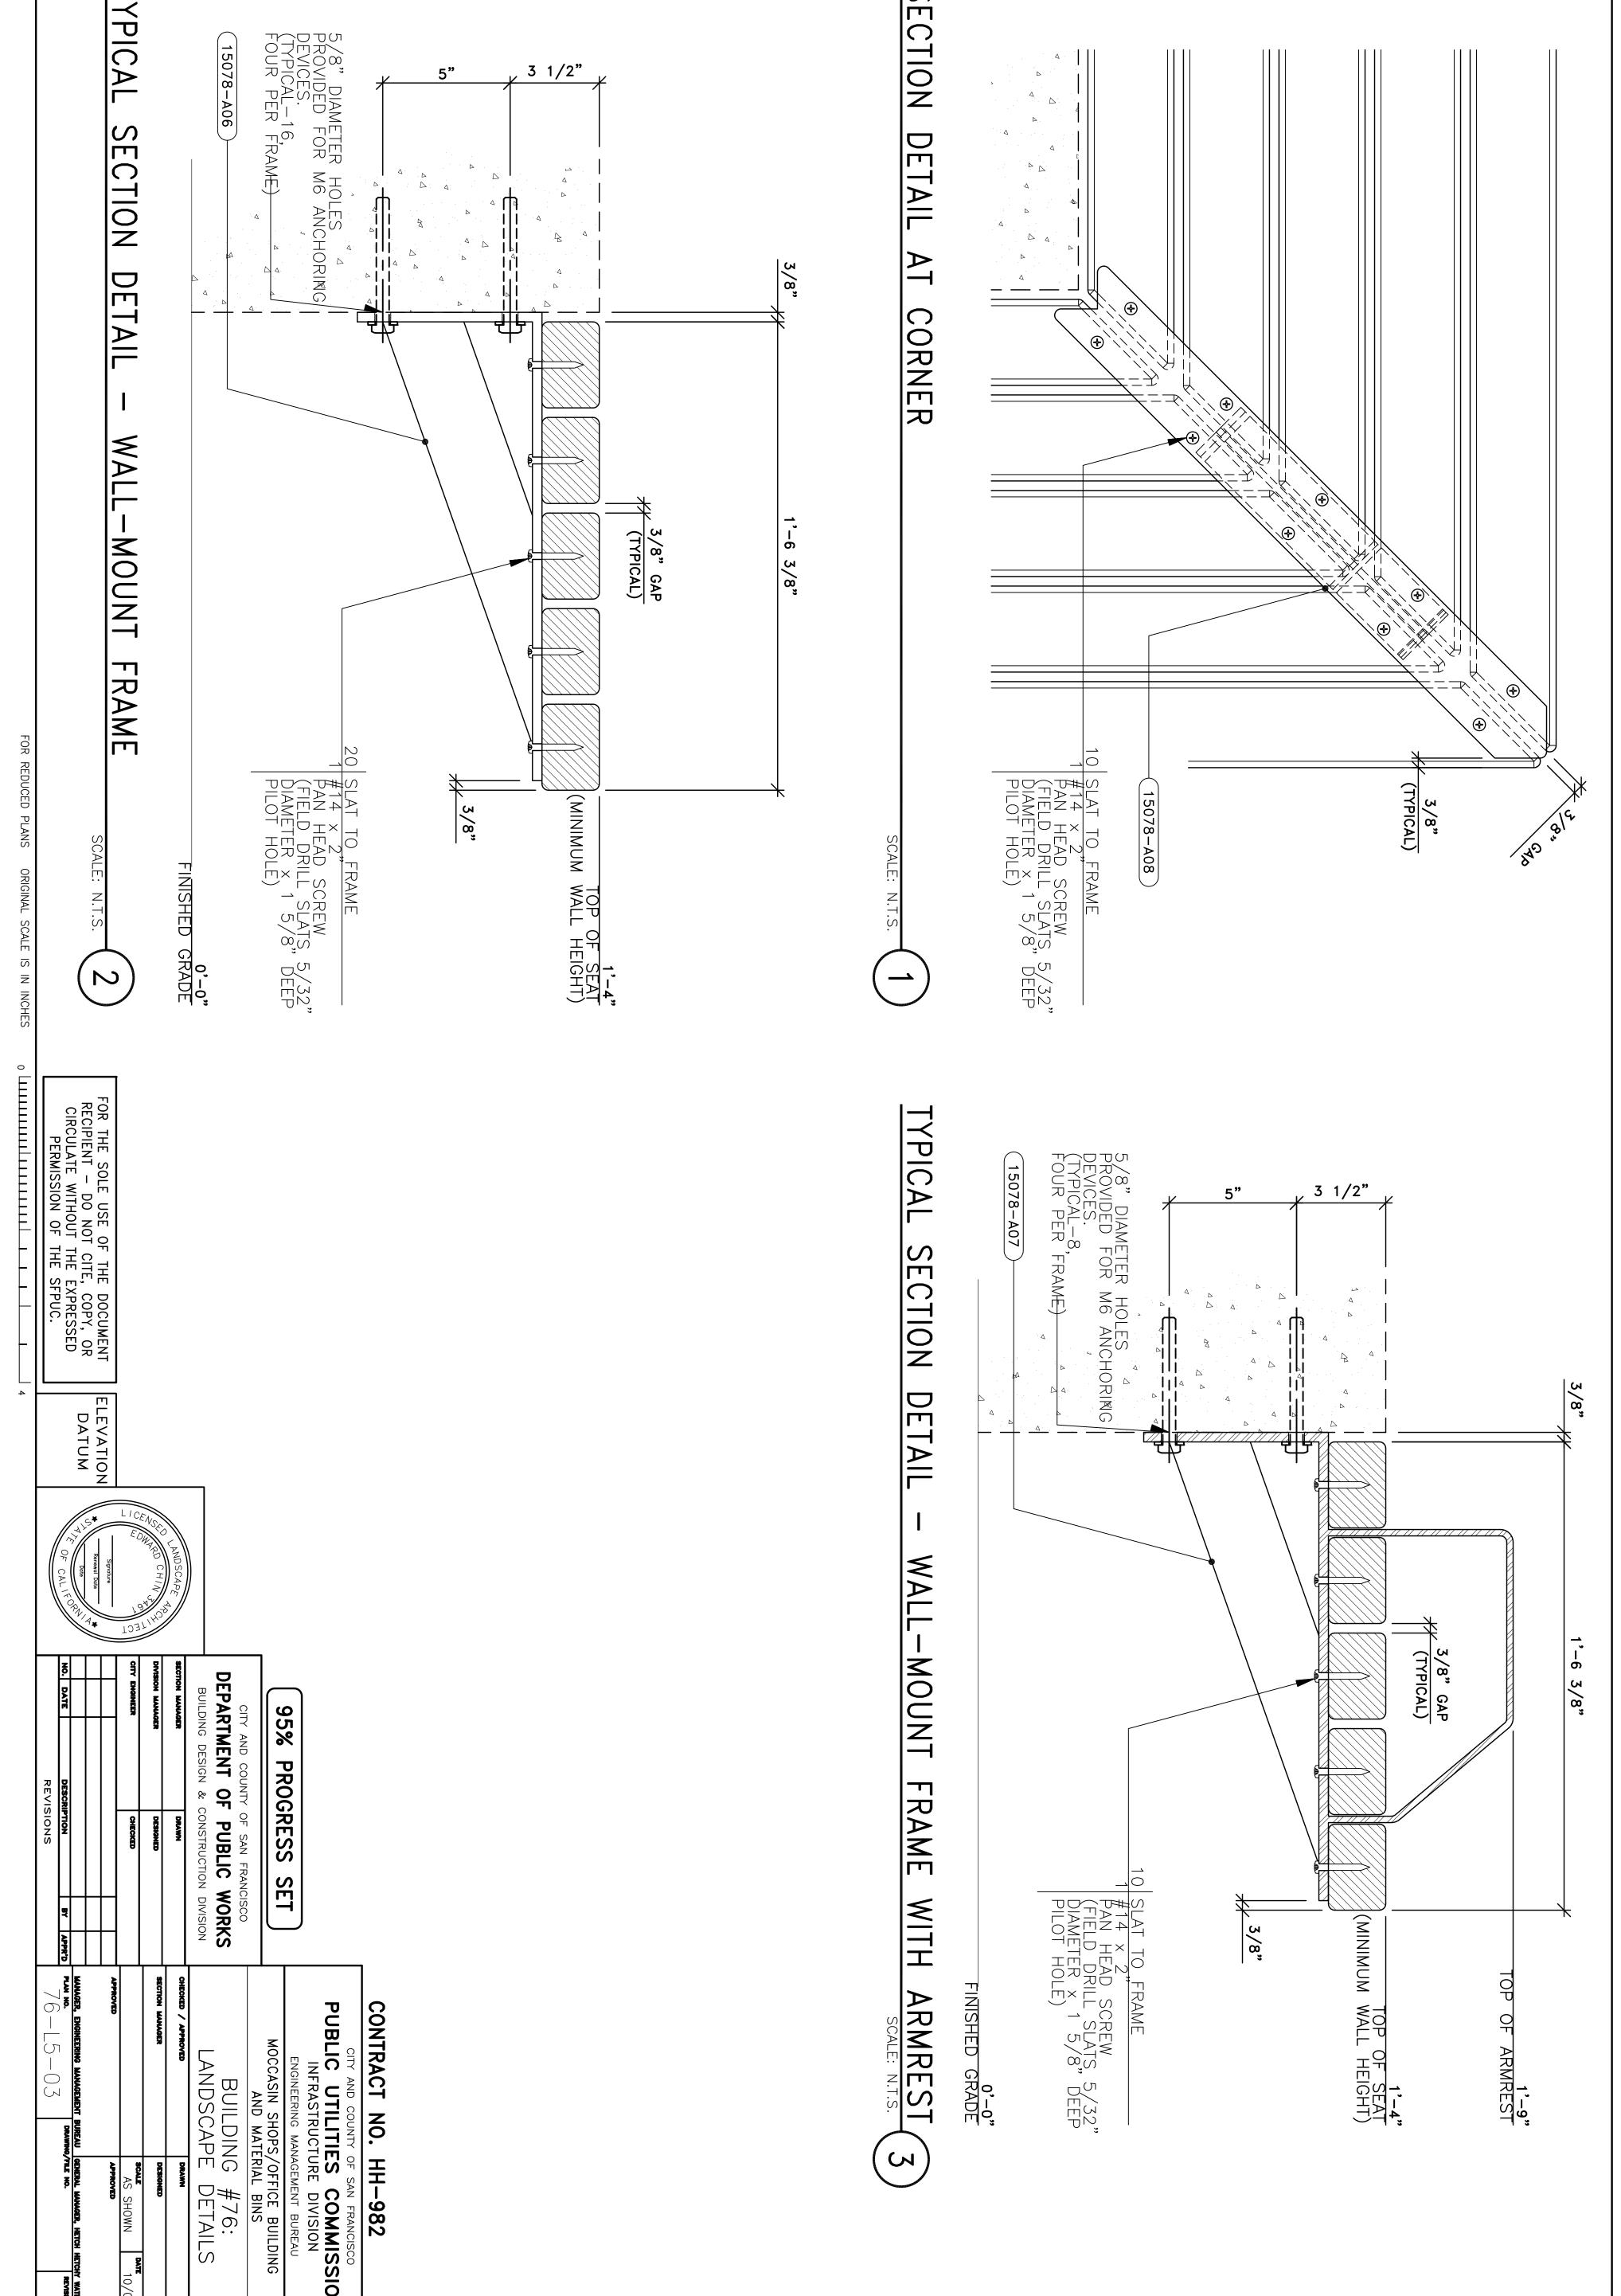


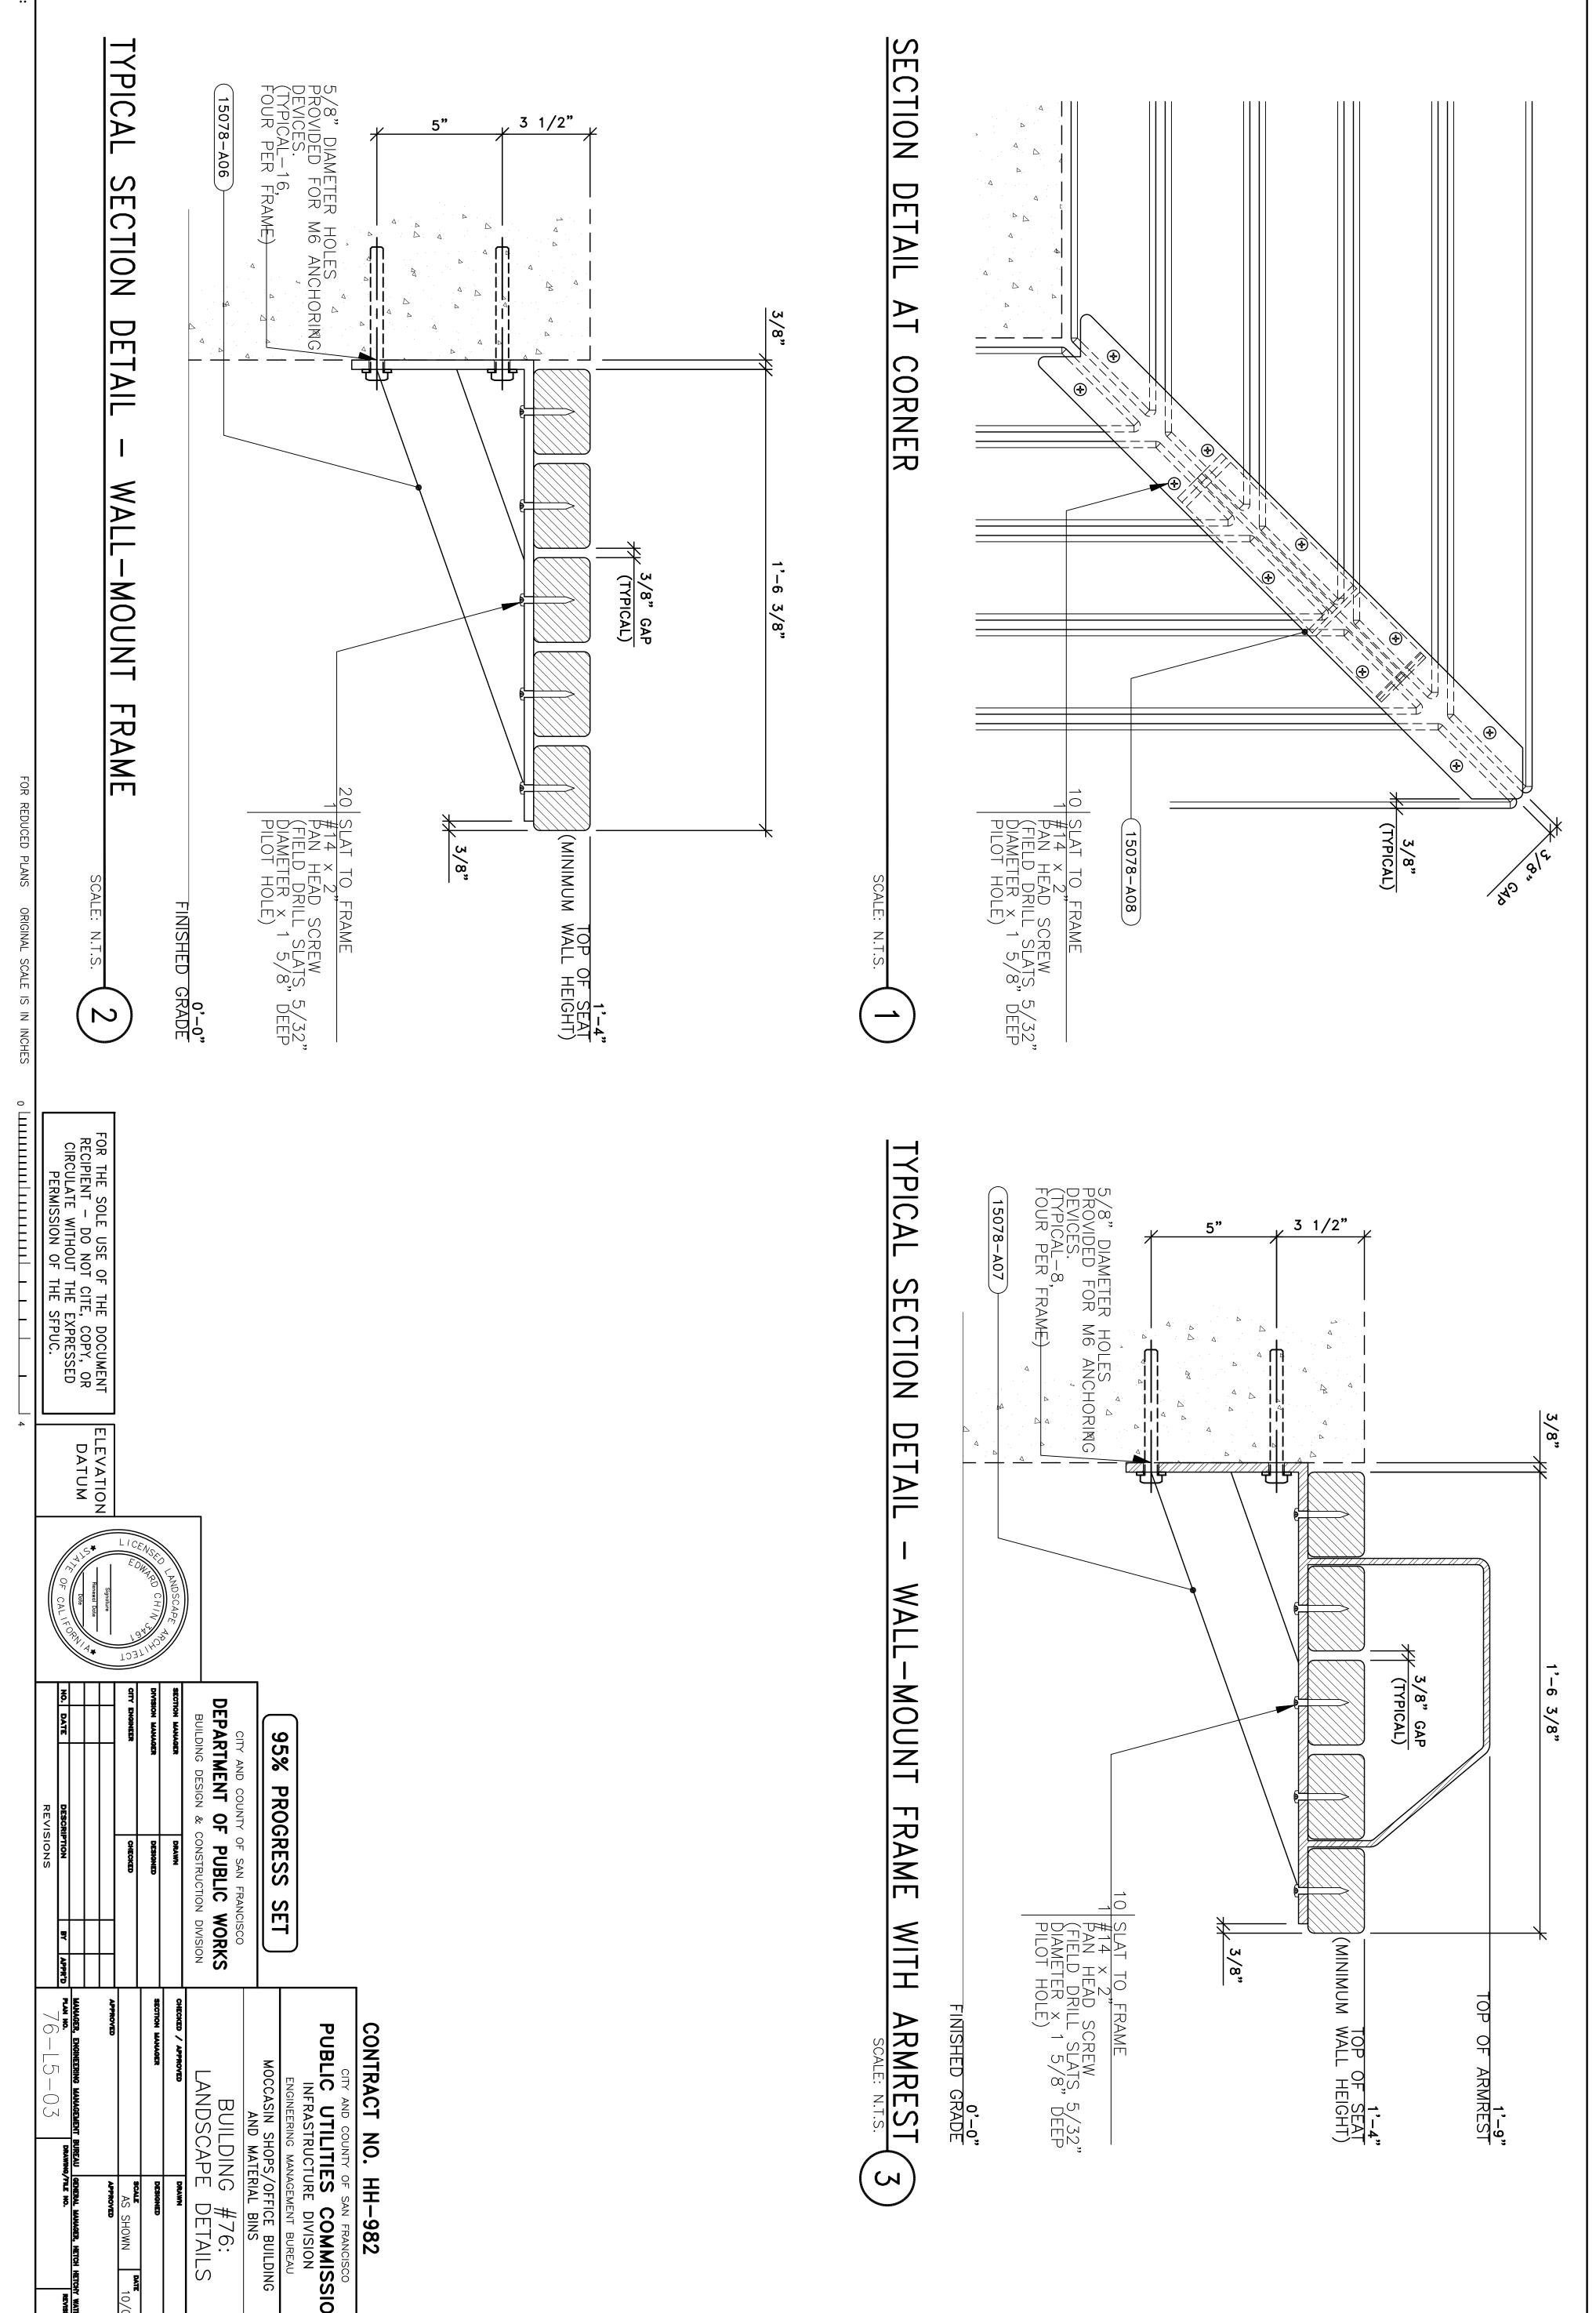


100 210

 
EXTENTS

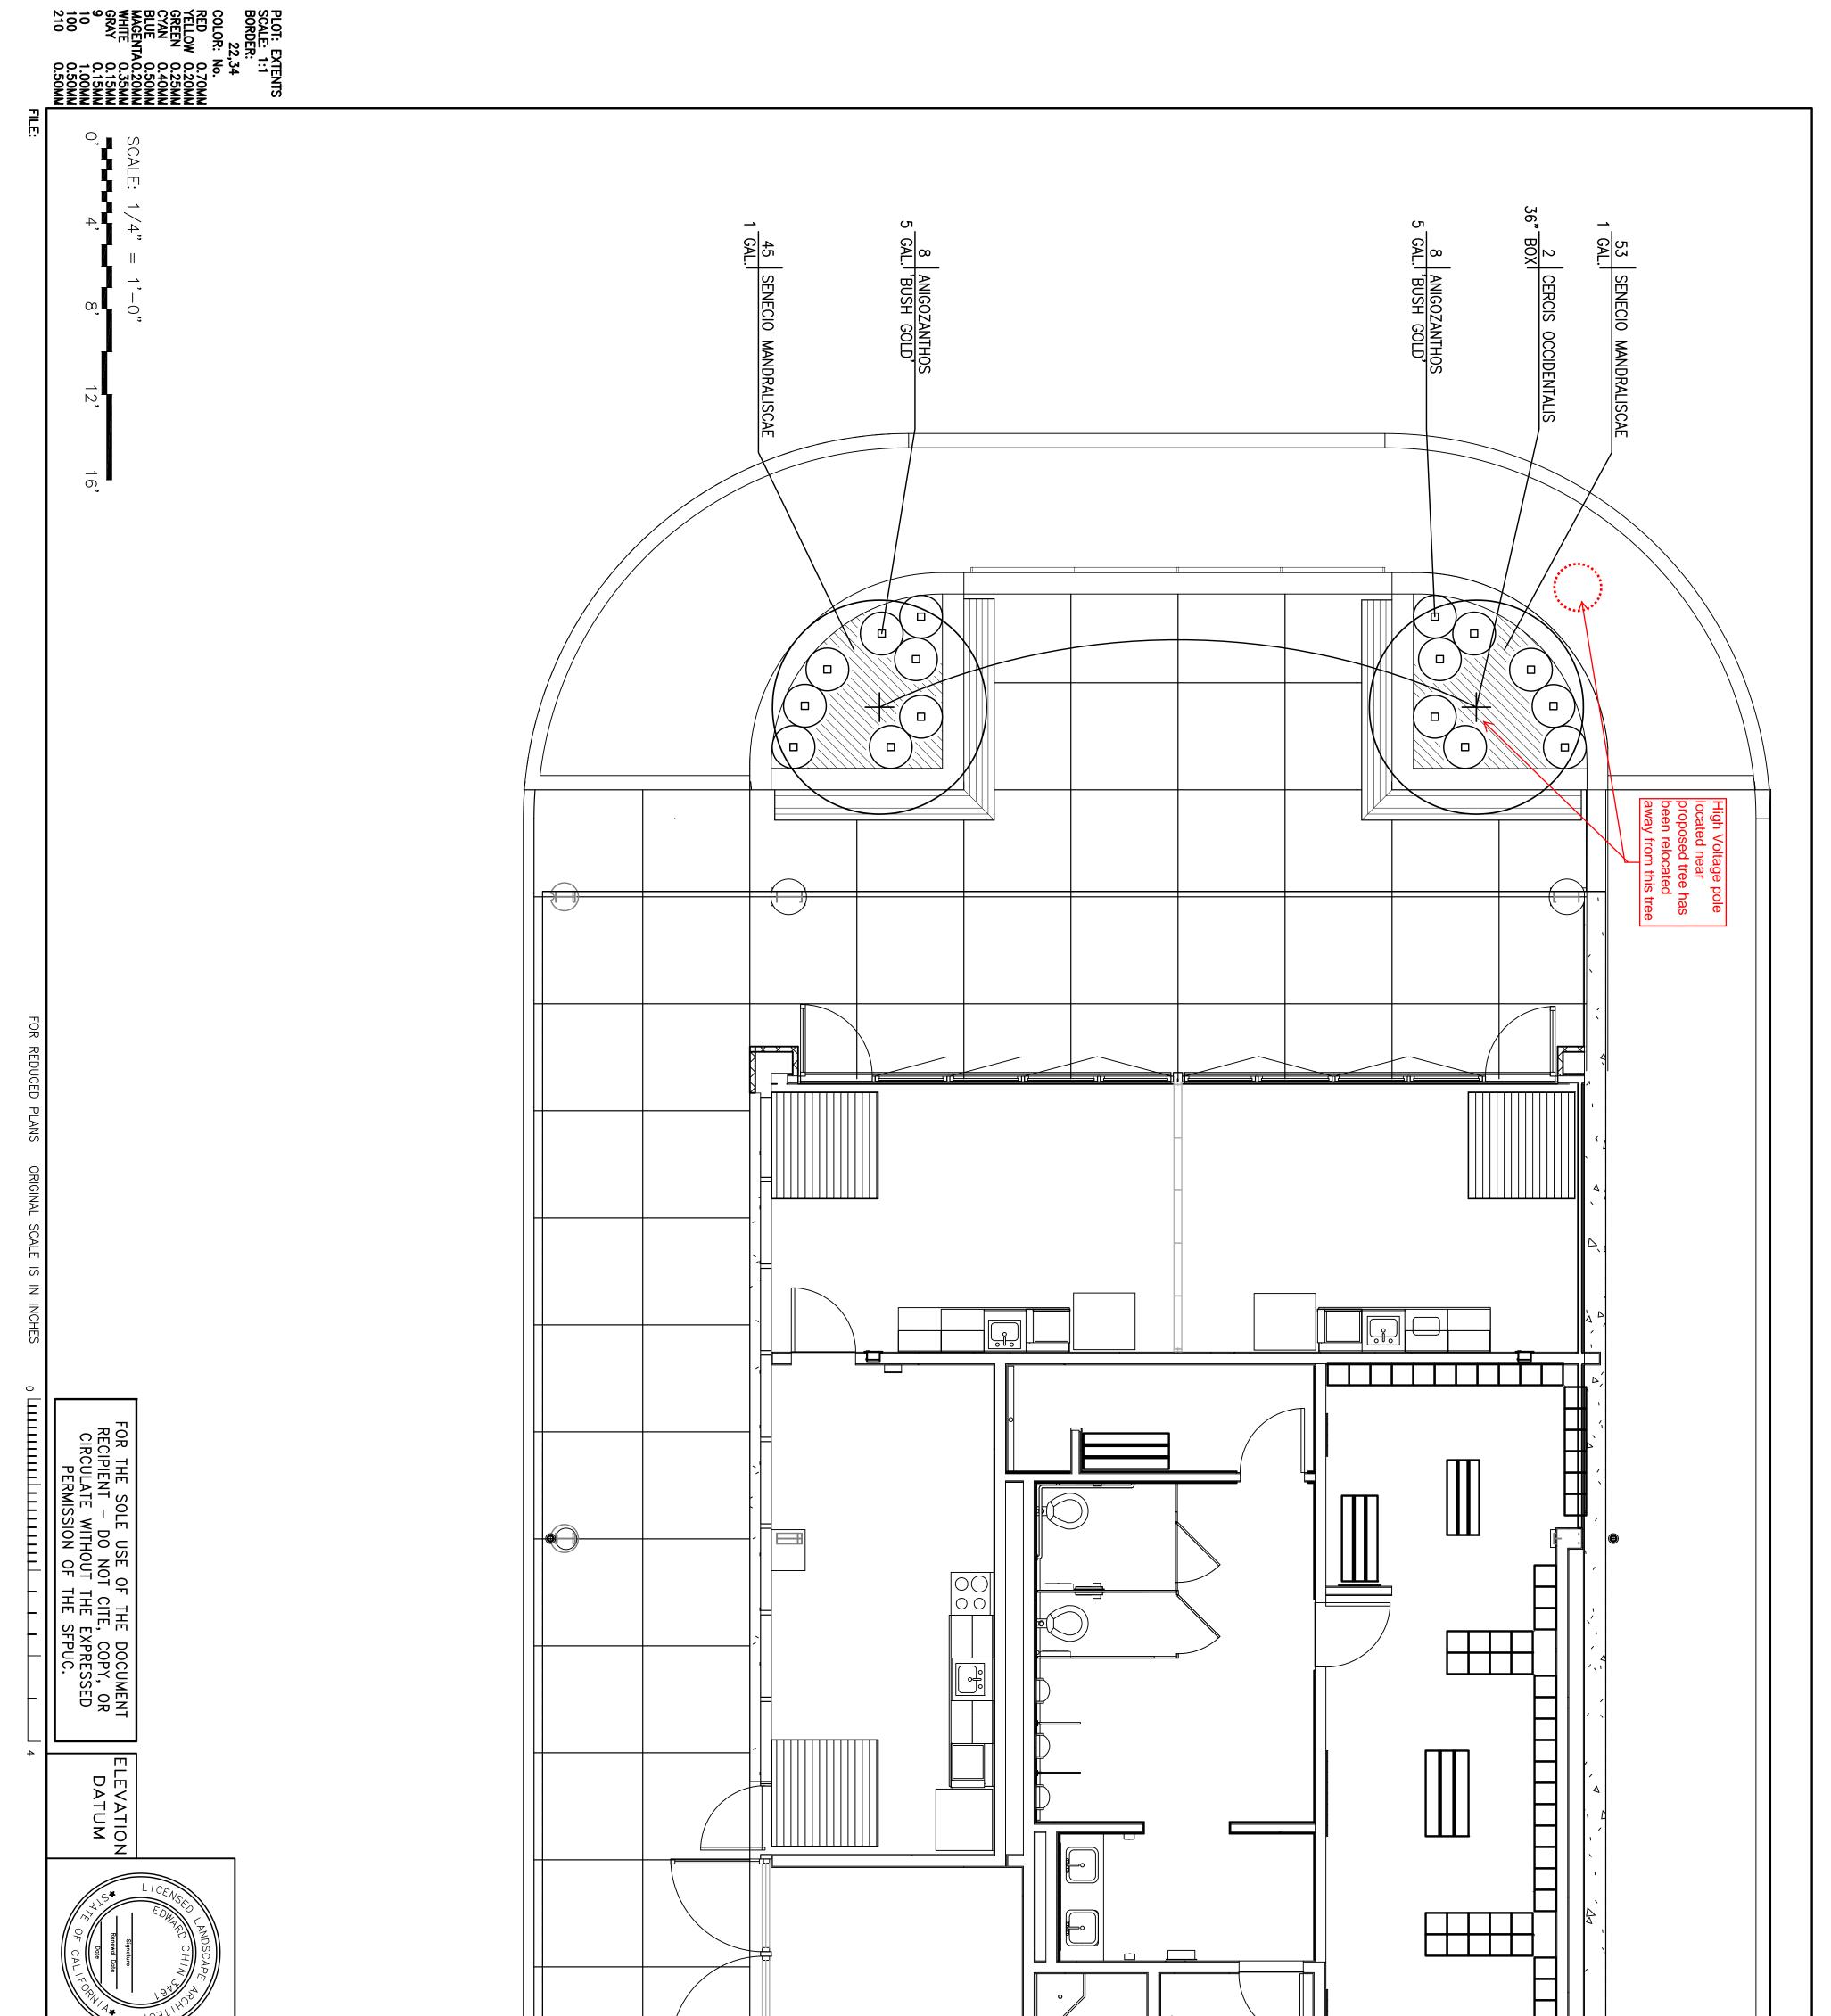

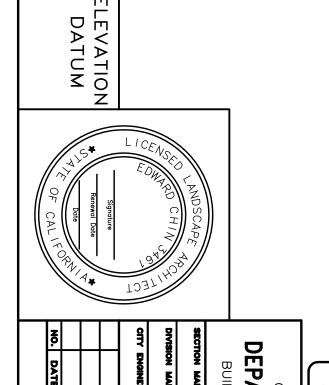



AMAGER DRAWN AMAGER DESIGNED EER CHIECKED FE DESCRIPTION BY APPR'D REVISIONS	G DESIGN & C	PLANTING NOTES 1. SEE SSDPW, SECTION 1007 "PLANTING", FOR AD 2. THE CITY REPRESENTATIVE SHALL INSPECT AND GROWING GROUNDS WITHIN A 50 MILE RADIUS OF 1 DELIVERY THE CITY REPRESENTATIVE SHALL INSPECT THE CONTRACTOR. REPLACE REJECTED MATERIAL. D APPROVED BY ENGINEER. 3. THE CITY REPRESENTATIVE RESERVES THE RIGHT AND DELETIONS IN THE PLANTING SCHEME AS THE PLANTING. LOCATIONS SHOWN ON PLANS ARE DIAGF GROUND WITHOUT APPROVAL ARE SUBJECT TO REJE 5. UNLESS OTHERWISE NOTED, ALL GROUND COVER TRIANGULAR. 6. ALL NEWLY PLANTED GROUND COVER AND SHRU SHREDDED BARK. SEE SPECIFICATIONS.	
CHECKED / APPROVED DRAWN SECTION MANAGER DESIONED SECTION MANAGER SCALE APPROVED SCALE APPROVED SATE APPROVED APPROVED MANAGER, ENGINEERING MANAGEMENT BUREAU GRAWNO/FILE NO. FLAN NO. DRAWNO/FILE NO. REVISION NO. 76-L4-03 DRAWNO/FILE NO. REVISION NO.	CONTRACT NO. HH-982 CITY AND COUNTY OF SAN FRANCISCO PUBLIC UTILITIES COMMISSION INFRASTRUCTURE DIVISION ENGINEERING MANAGEMENT BUREAU MOCCASIN SHOPS/OFFICE BUILDING AND MATERIAL BINS BUILDING #76: PLANTING PLAN	 PLANTING NOTES 1. SEE SSDPW, SECTION 1007 "PLANTING", FOR ADDITIONAL PLANTING INFORMATION. 2. THE CITY REPRESENTATIVE SHALL INSPECT AND TAG ALL PLANT MATERIALS AT NURSERY GROWING GROUNDS WITHIN A 50 MILE RADIUS OF CITY HALL PRIOR TO DELIVERY. UPON DELEVERY THE CITY REPRESENTATIVE SHALL INSPECT AND APPROVE PLANT MATERIAL WITH THE CONTRACTOR. REPLACE REJECTED MATERIAL. DO NOT PLANT UNTIL LAYOUT IS APPROVED BY ENGINEER. 3. THE CITY REPRESENTATIVE RESERVES THE RIGHT TO MAKE SUBSTITUTIONS, ADDITIONS AND DELETIONS IN THE PLANTING SCHEME AS THE WORK PROGRESSES. 4. REVIEW PLANT MATERIAL LOCATION WITH CITY REPRESENTATIVE PRIOR TO FINAL PLANTING. LOCATIONS SHOWN ON PLANS ARE DIAGRAMMATIC ONLY. PLANTS PLACED IN GROUND WITHOUT APPROVAL ARE SUBJECT TO REJECTION. 5. UNLESS OTHERWISE NOTED, ALL GROUND COVER AND SHRUB SHALL BE SPACED TRIANGULAR. 6. ALL NEWLY PLANTED GROUND COVER AND SHRUB AREAS TO RECEIVE 2" MIN. SHREDDED BARK. SEE SPECIFICATIONS. 	

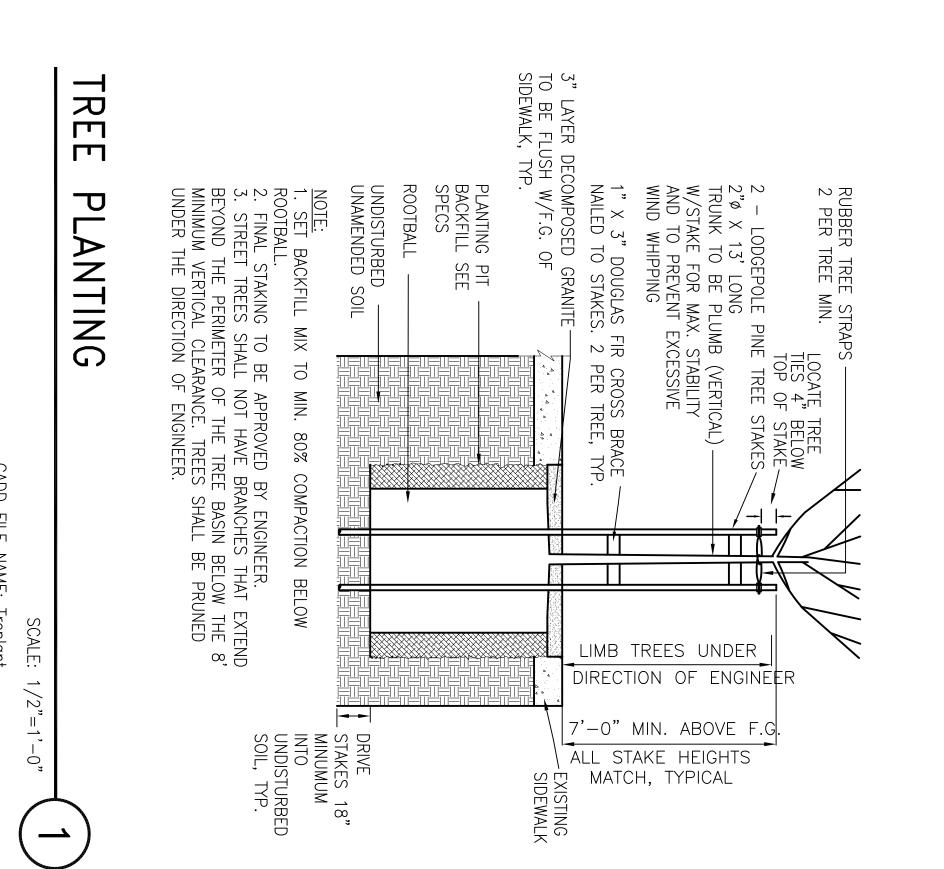


CADD FILE NAME: Treplant DATE: 11-02

22,34 COLOR: No. RED 0.70MM YELLOW 0.20MM GREEN 0.25MM BLUE 0.50MM MAGENTA 0.25MM MAGENTA 0.25MM MAGENTA 0.25MM MAGENTA 0.25MM 100 0.50MM 100 0.50MM

FILE:

Plot: extents Scale: 1:1 Border:

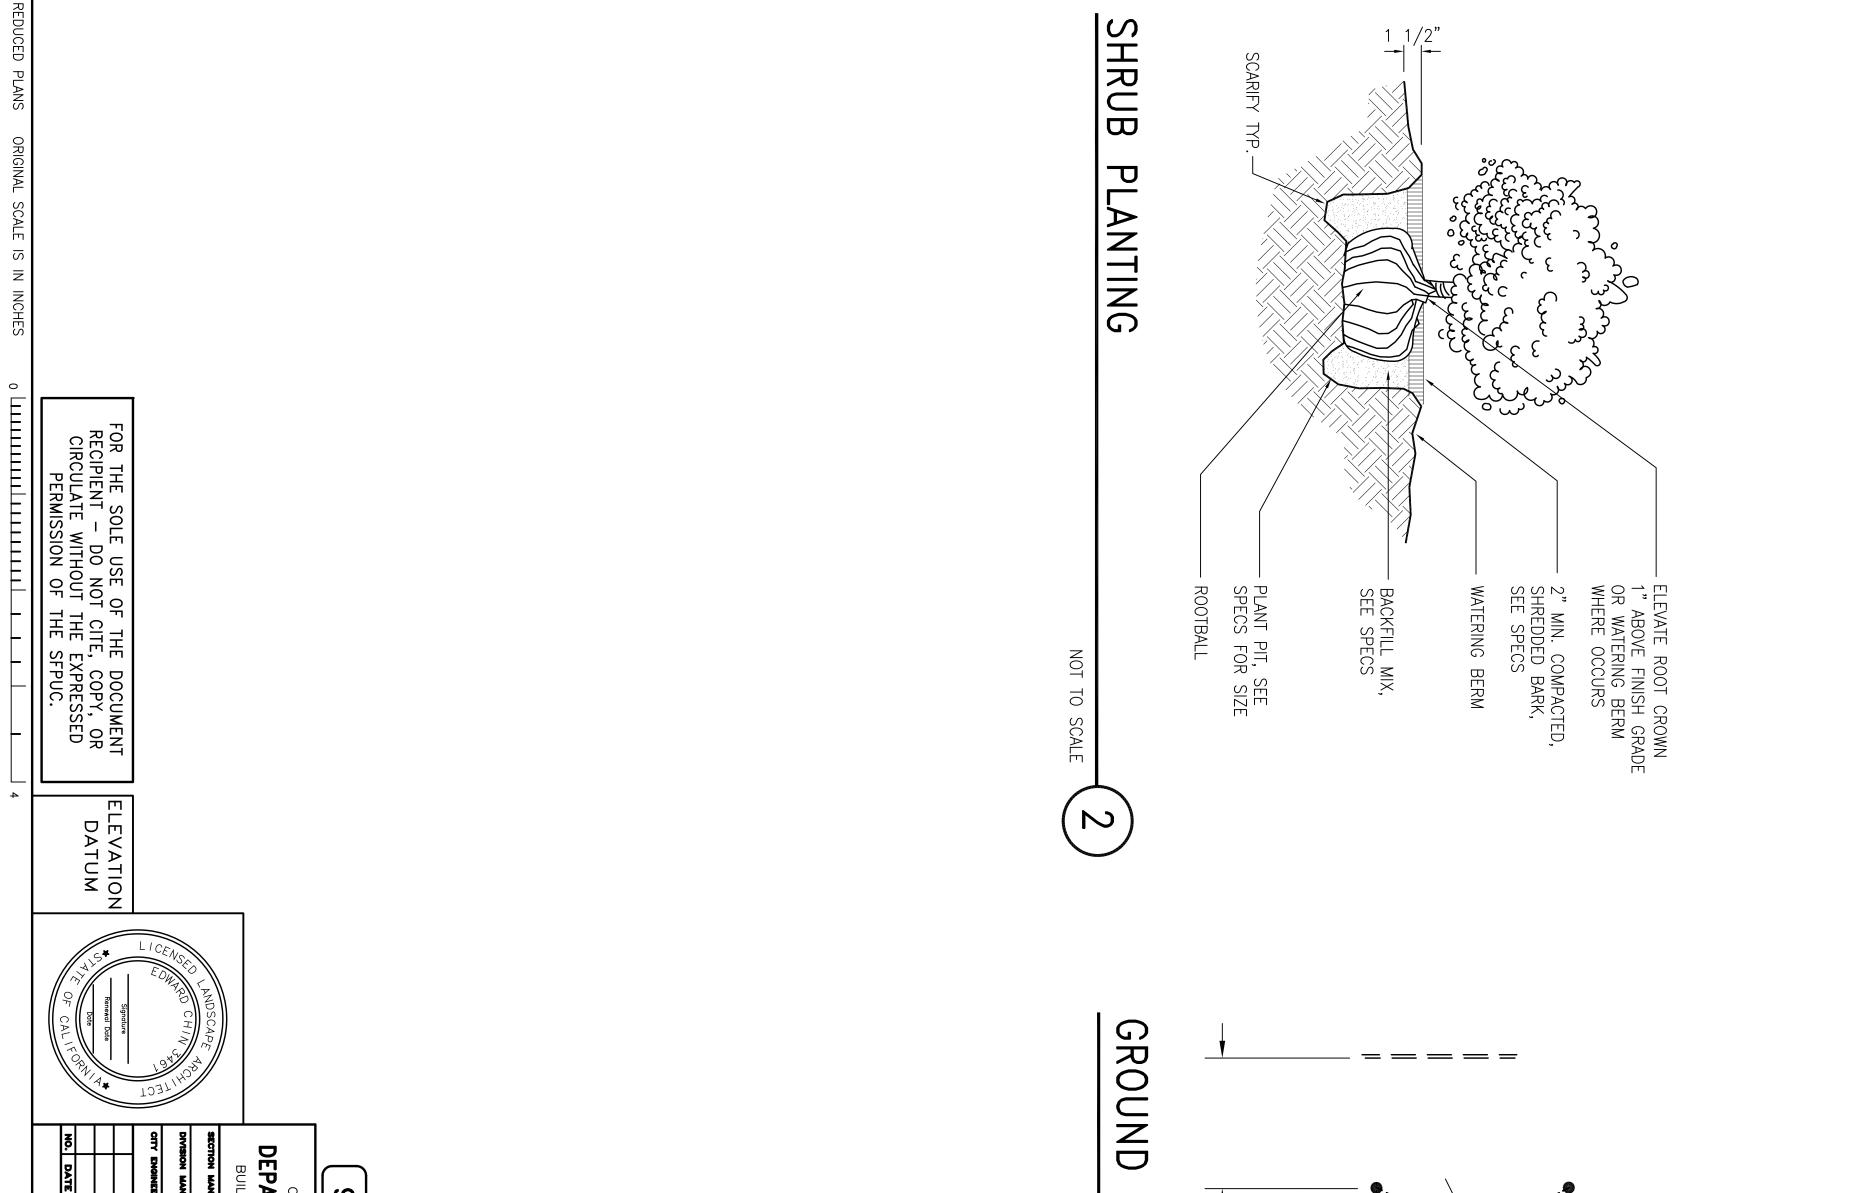

С			/b-L5-U4			REVISIONS	REVIS	
REVISION NO.	/FLE NO.	DRAWING,	PCN NO.	APPR'D	R	PTION	DESCRIPTION	1.4
TCHY WATER AND POWER	UREAU GENERAL MANAGER, HETCH HETCHY WATER AND POWER	BUREAU	MANAGER, ENGINEERING MANAGEMENT BUREAU					
	APPROVED		APPROVED					
10/08/15	AS SHOWN					CHECKED	~	9
			SECTION MANAGER			DESIGNED	NAGER	ž
	URAWN		CHECKED / APPROVED			DRAWN	NAGER	ž
					DIVISIO	CONSTRUCTION	LDING DESIGN & CONSTRUCTION DIVISION	
	IG #76:		BUILDING	Ś	VOR	PUBLIC V	ARTMENT OF PUBLIC WORKS	
G G	AND MATERIAL BINS	MATE	MUCCASIN S AND					2
5	ENGINEERING MANAGEMENT BUREAU	IG MAN	ENGINEERIN		–	RESS SE	95% PROGRESS SET	G
SION	URE DIVISION	RUCTI	PUBLIC UTILITIES		J			
		JUNITY	CITY AND CC					
	HH-982	0	CONTRACT NO. HH					

---- 12" MIN. CLEARANCE FROM TREE TRUNKS, WHERE OCCURS. Ň × X 4" MIN. FROM EDGE OF PLANTING AREA. NOTE : EDGE OF PLANTING AREA, SEE LAYOUT PLANS. GROUND COVER PLANT, TYP.

COVER **PLANTING**

CADD FILE NAME: Gcp DATE: 11-02

SCALE : 1"=1'-0"

З

FOR GROUND COVER SPACING DISTANCE "X", SEE PLANT LIST.